



(L8-81-8) LbbC-d

20010120-0803 FERC PDF (Unofficial) 03/13/1987

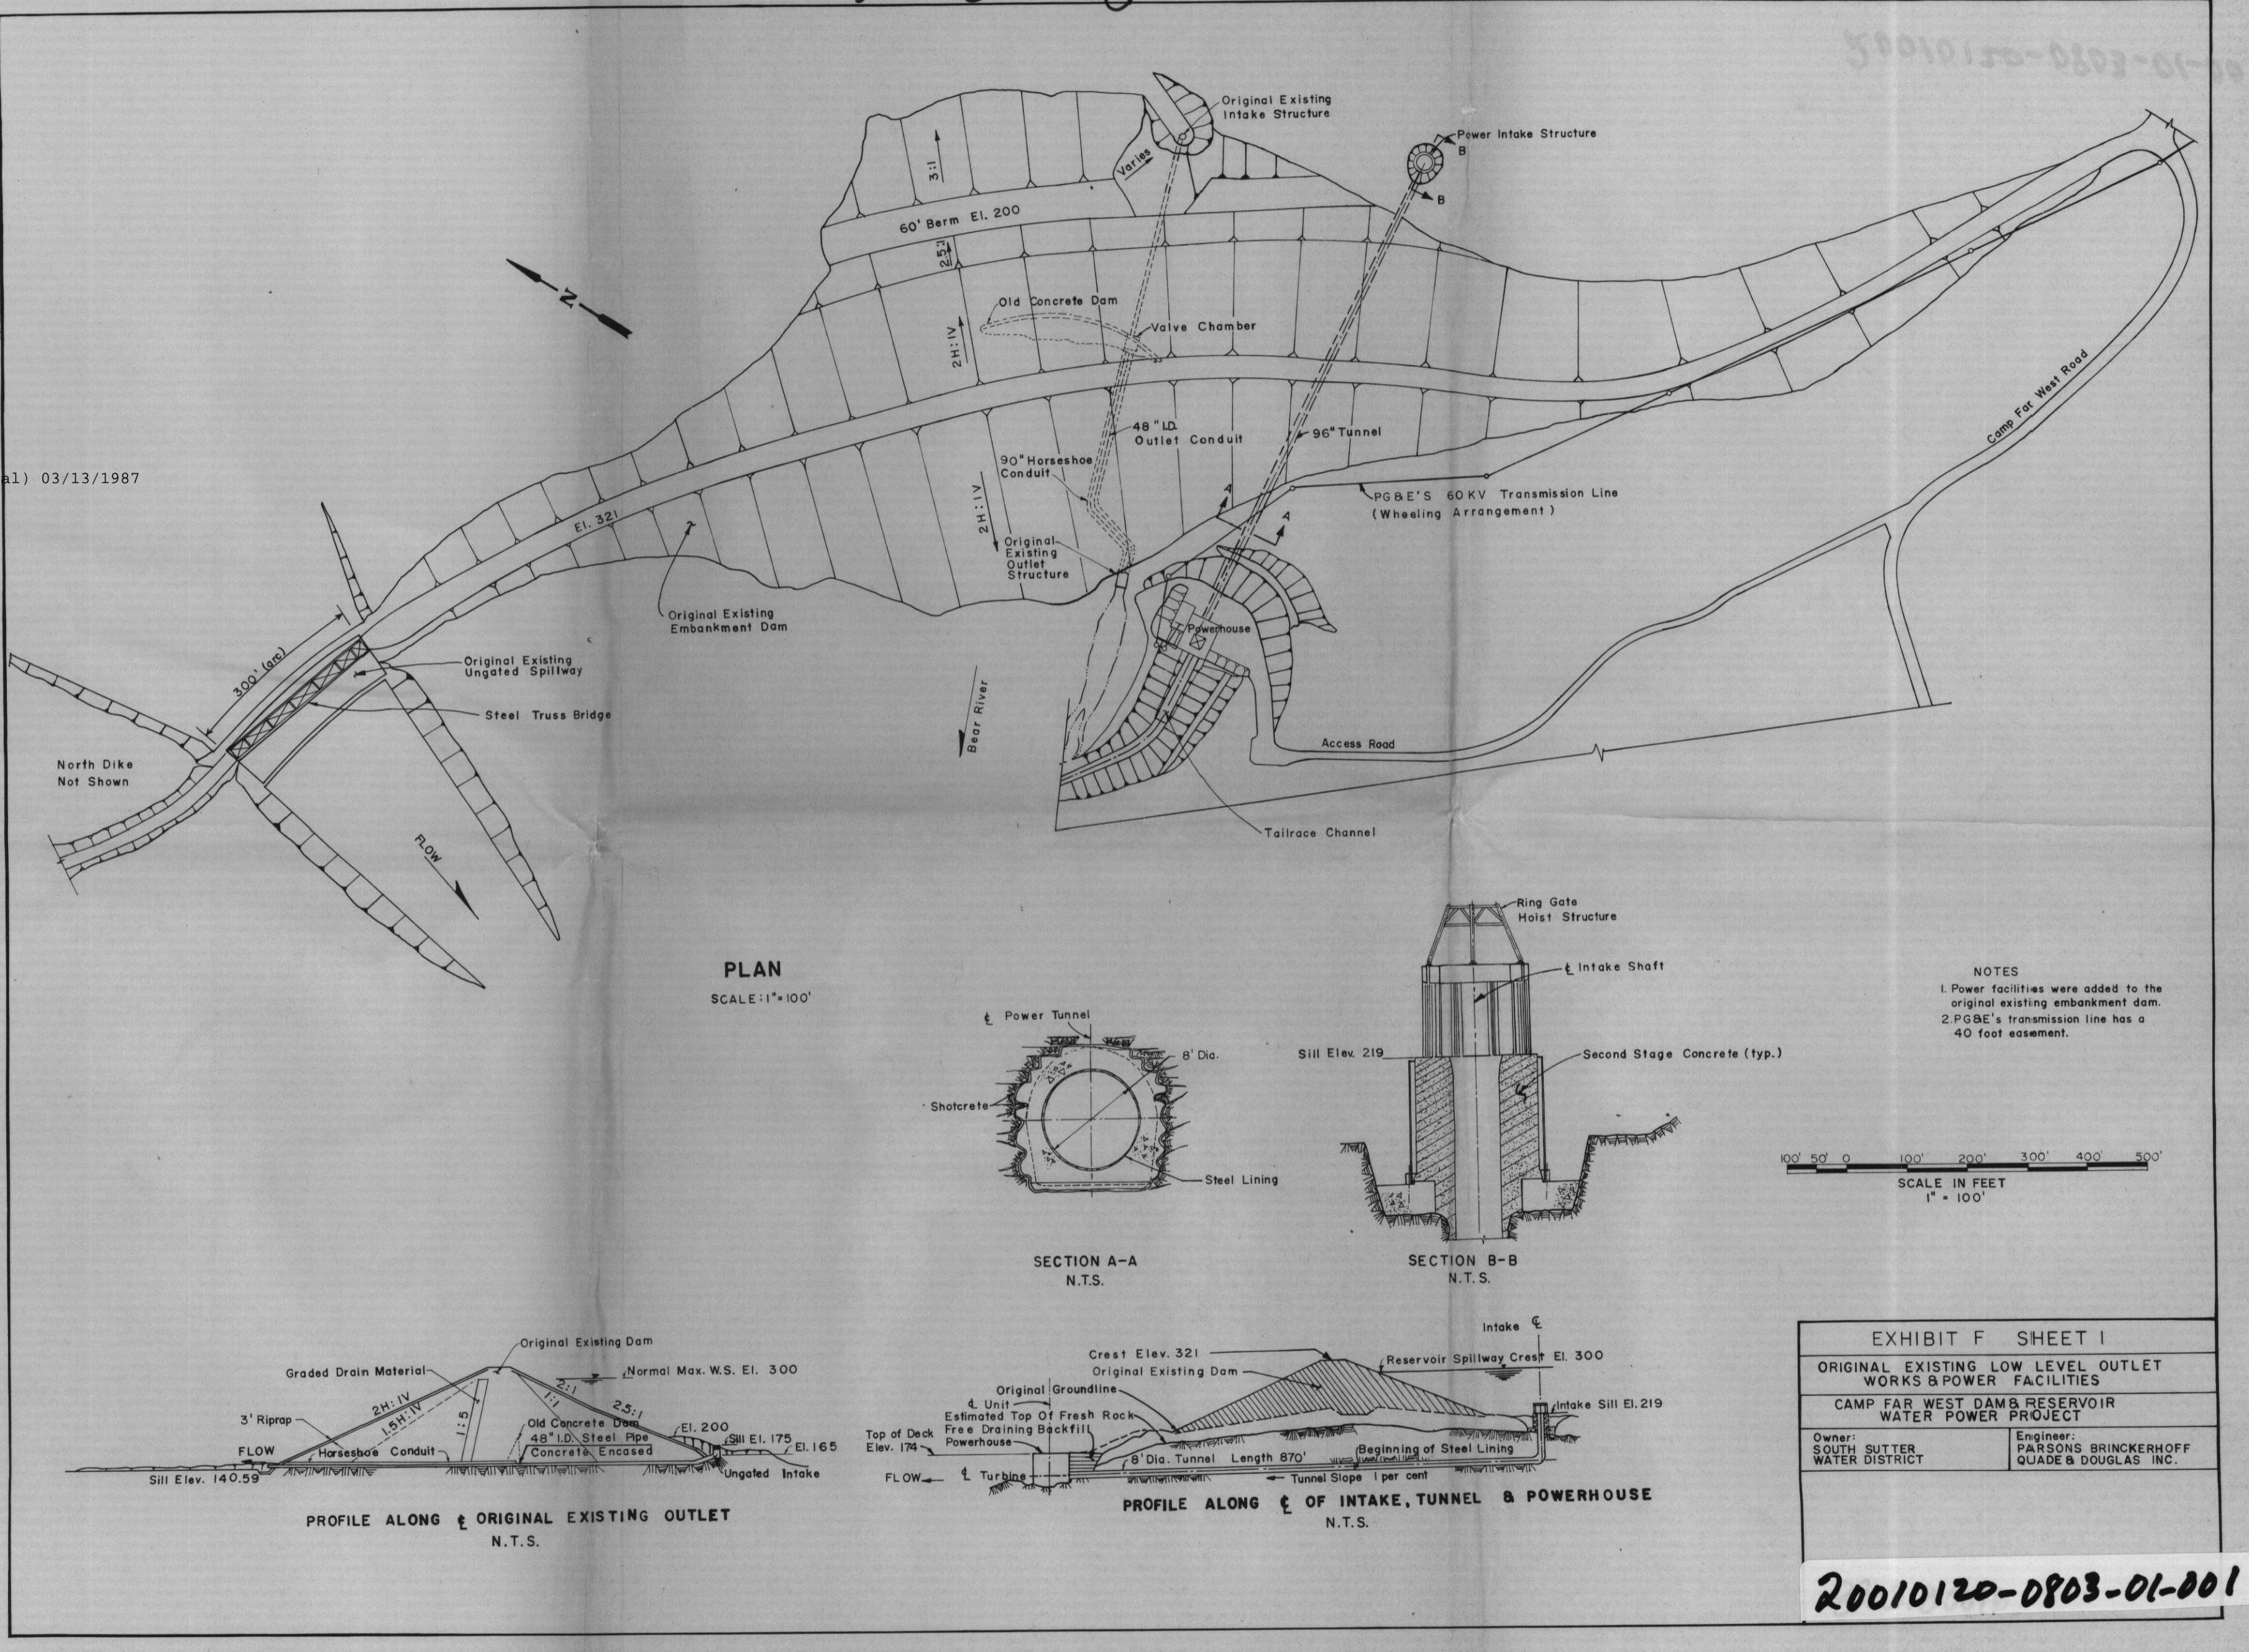


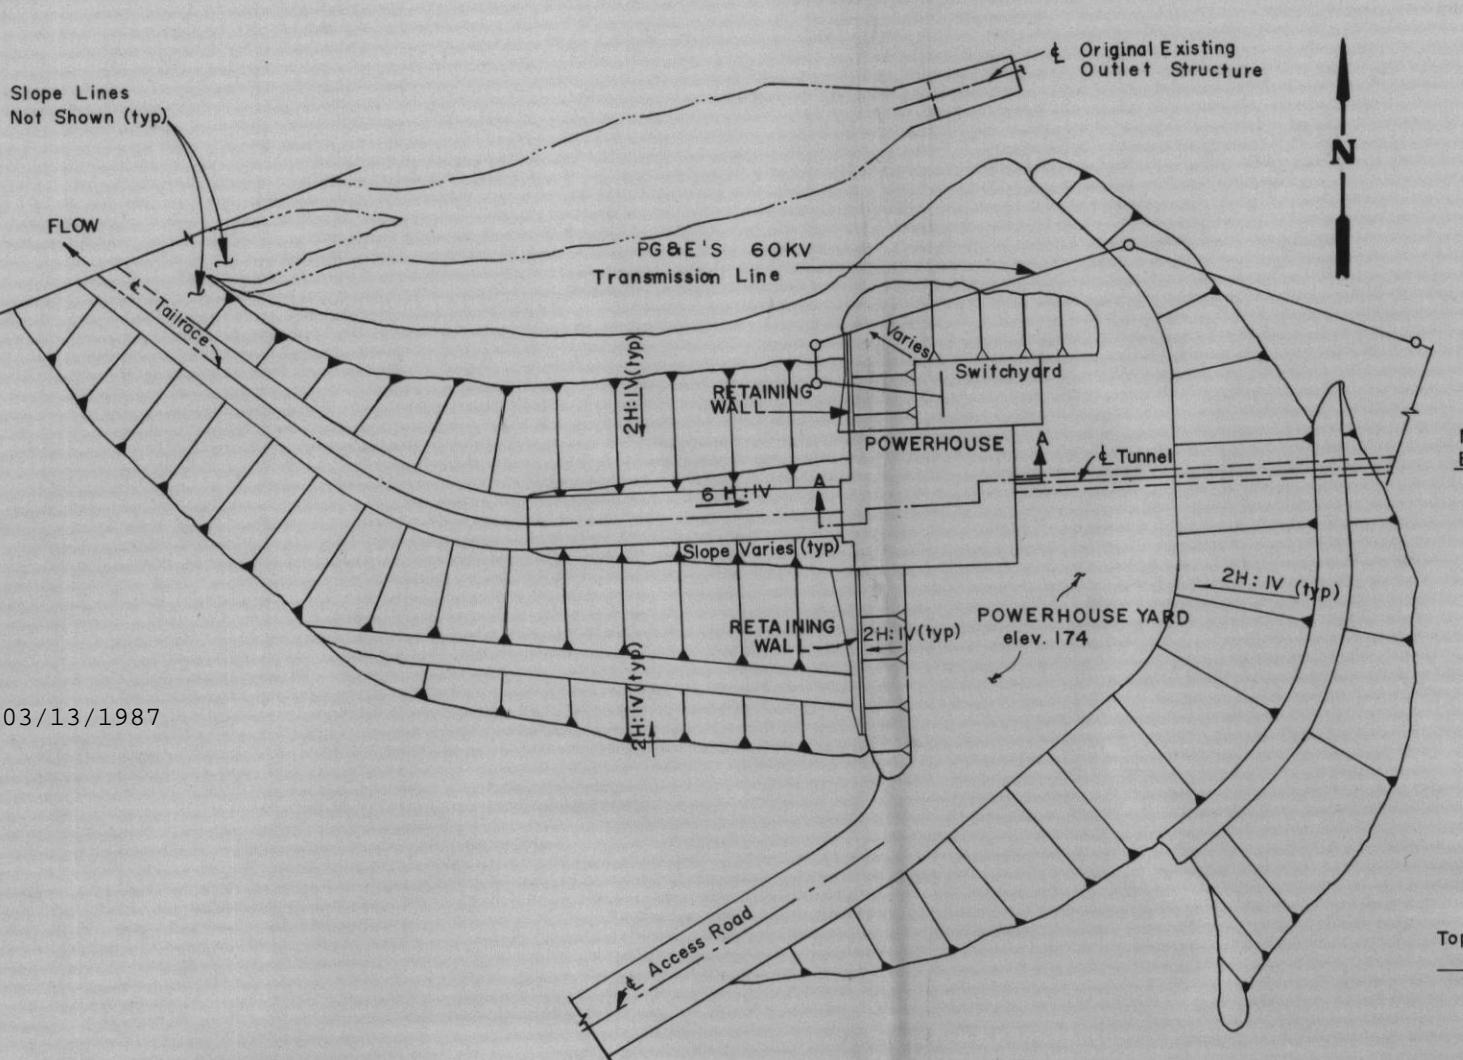

20010120-0803 FERC PDF (Unofficial) 03/13/1987


SITE PLAN

SCALE: 1" = 40'
(APPROXIMATE)

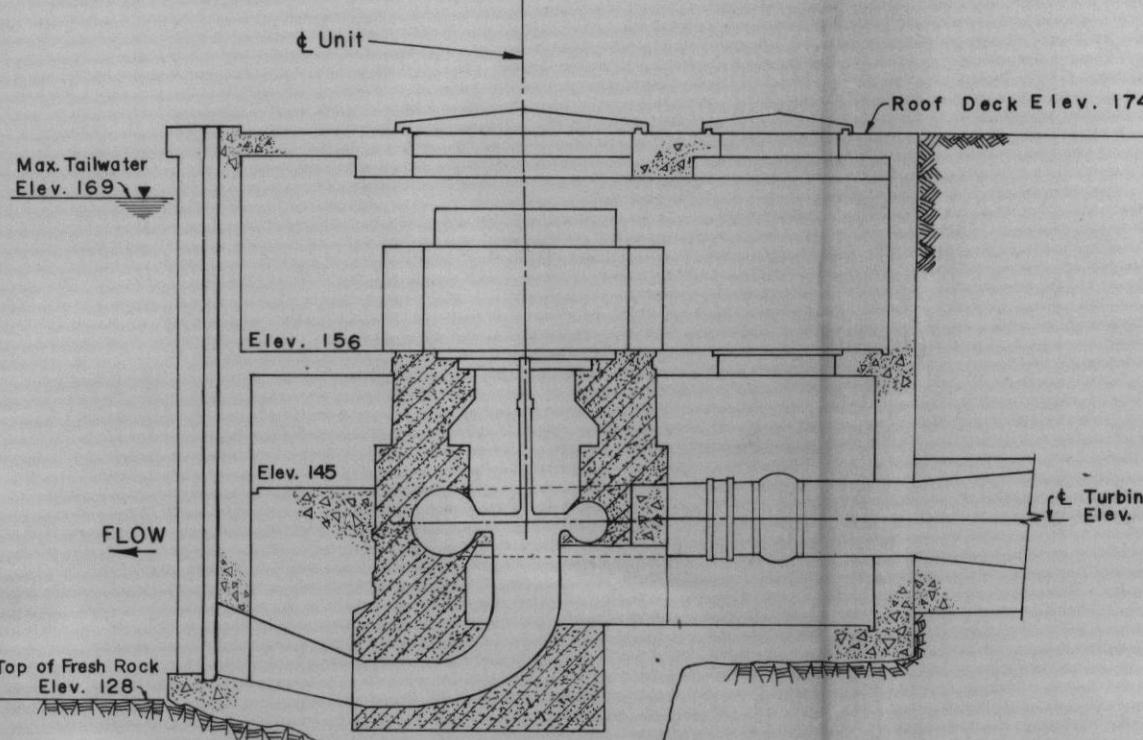


SECTION A-A

NTS.

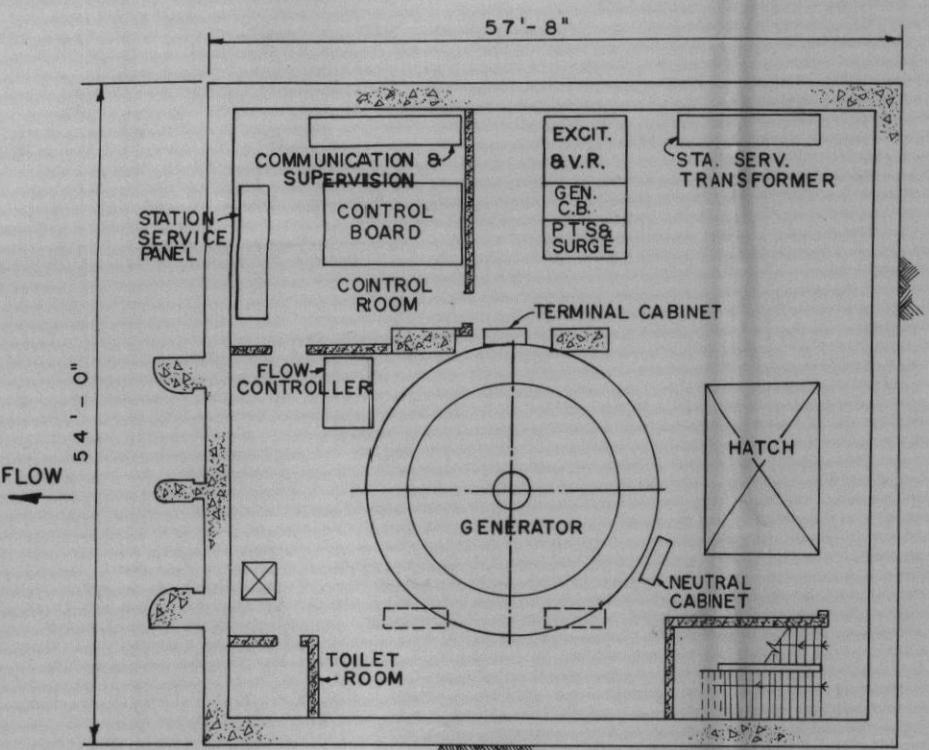

GENERATOR FLOOR - EL. 156

NTS.

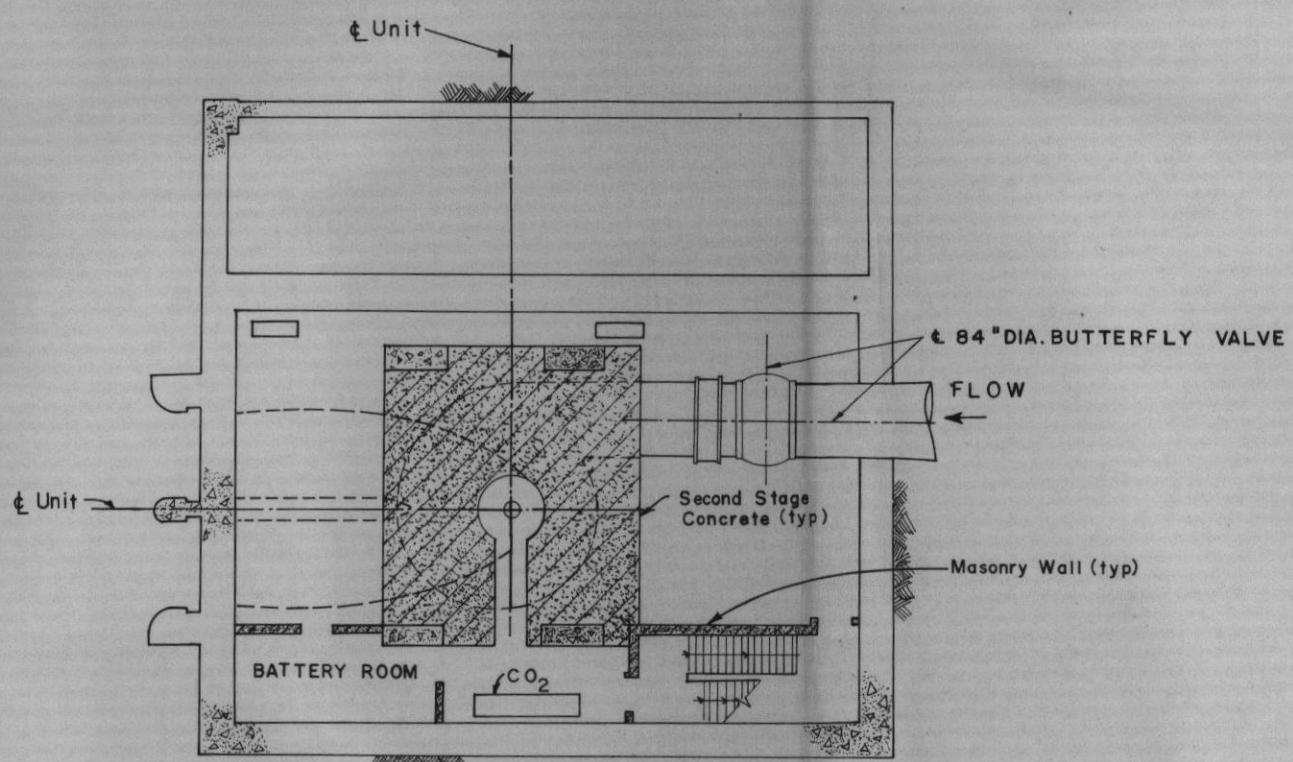

TURBINE FLOOR - EL. 145

NTS.


**EXHIBIT F SHEET 2
POWERHOUSE PLAN & SECTIONS
CAMP FAR WEST DAM & RESERVOIR
WATER POWER PROJECT**

Owner:
SOUTH SUTTER
WATER DISTRICT


Engineer:
PARSONS BRINCKERHOFF
QUADE & DOUGLAS, INC.

20010120-0803-01-002

20010120-0803 FERC PDF (Unofficial) 03/13/1987

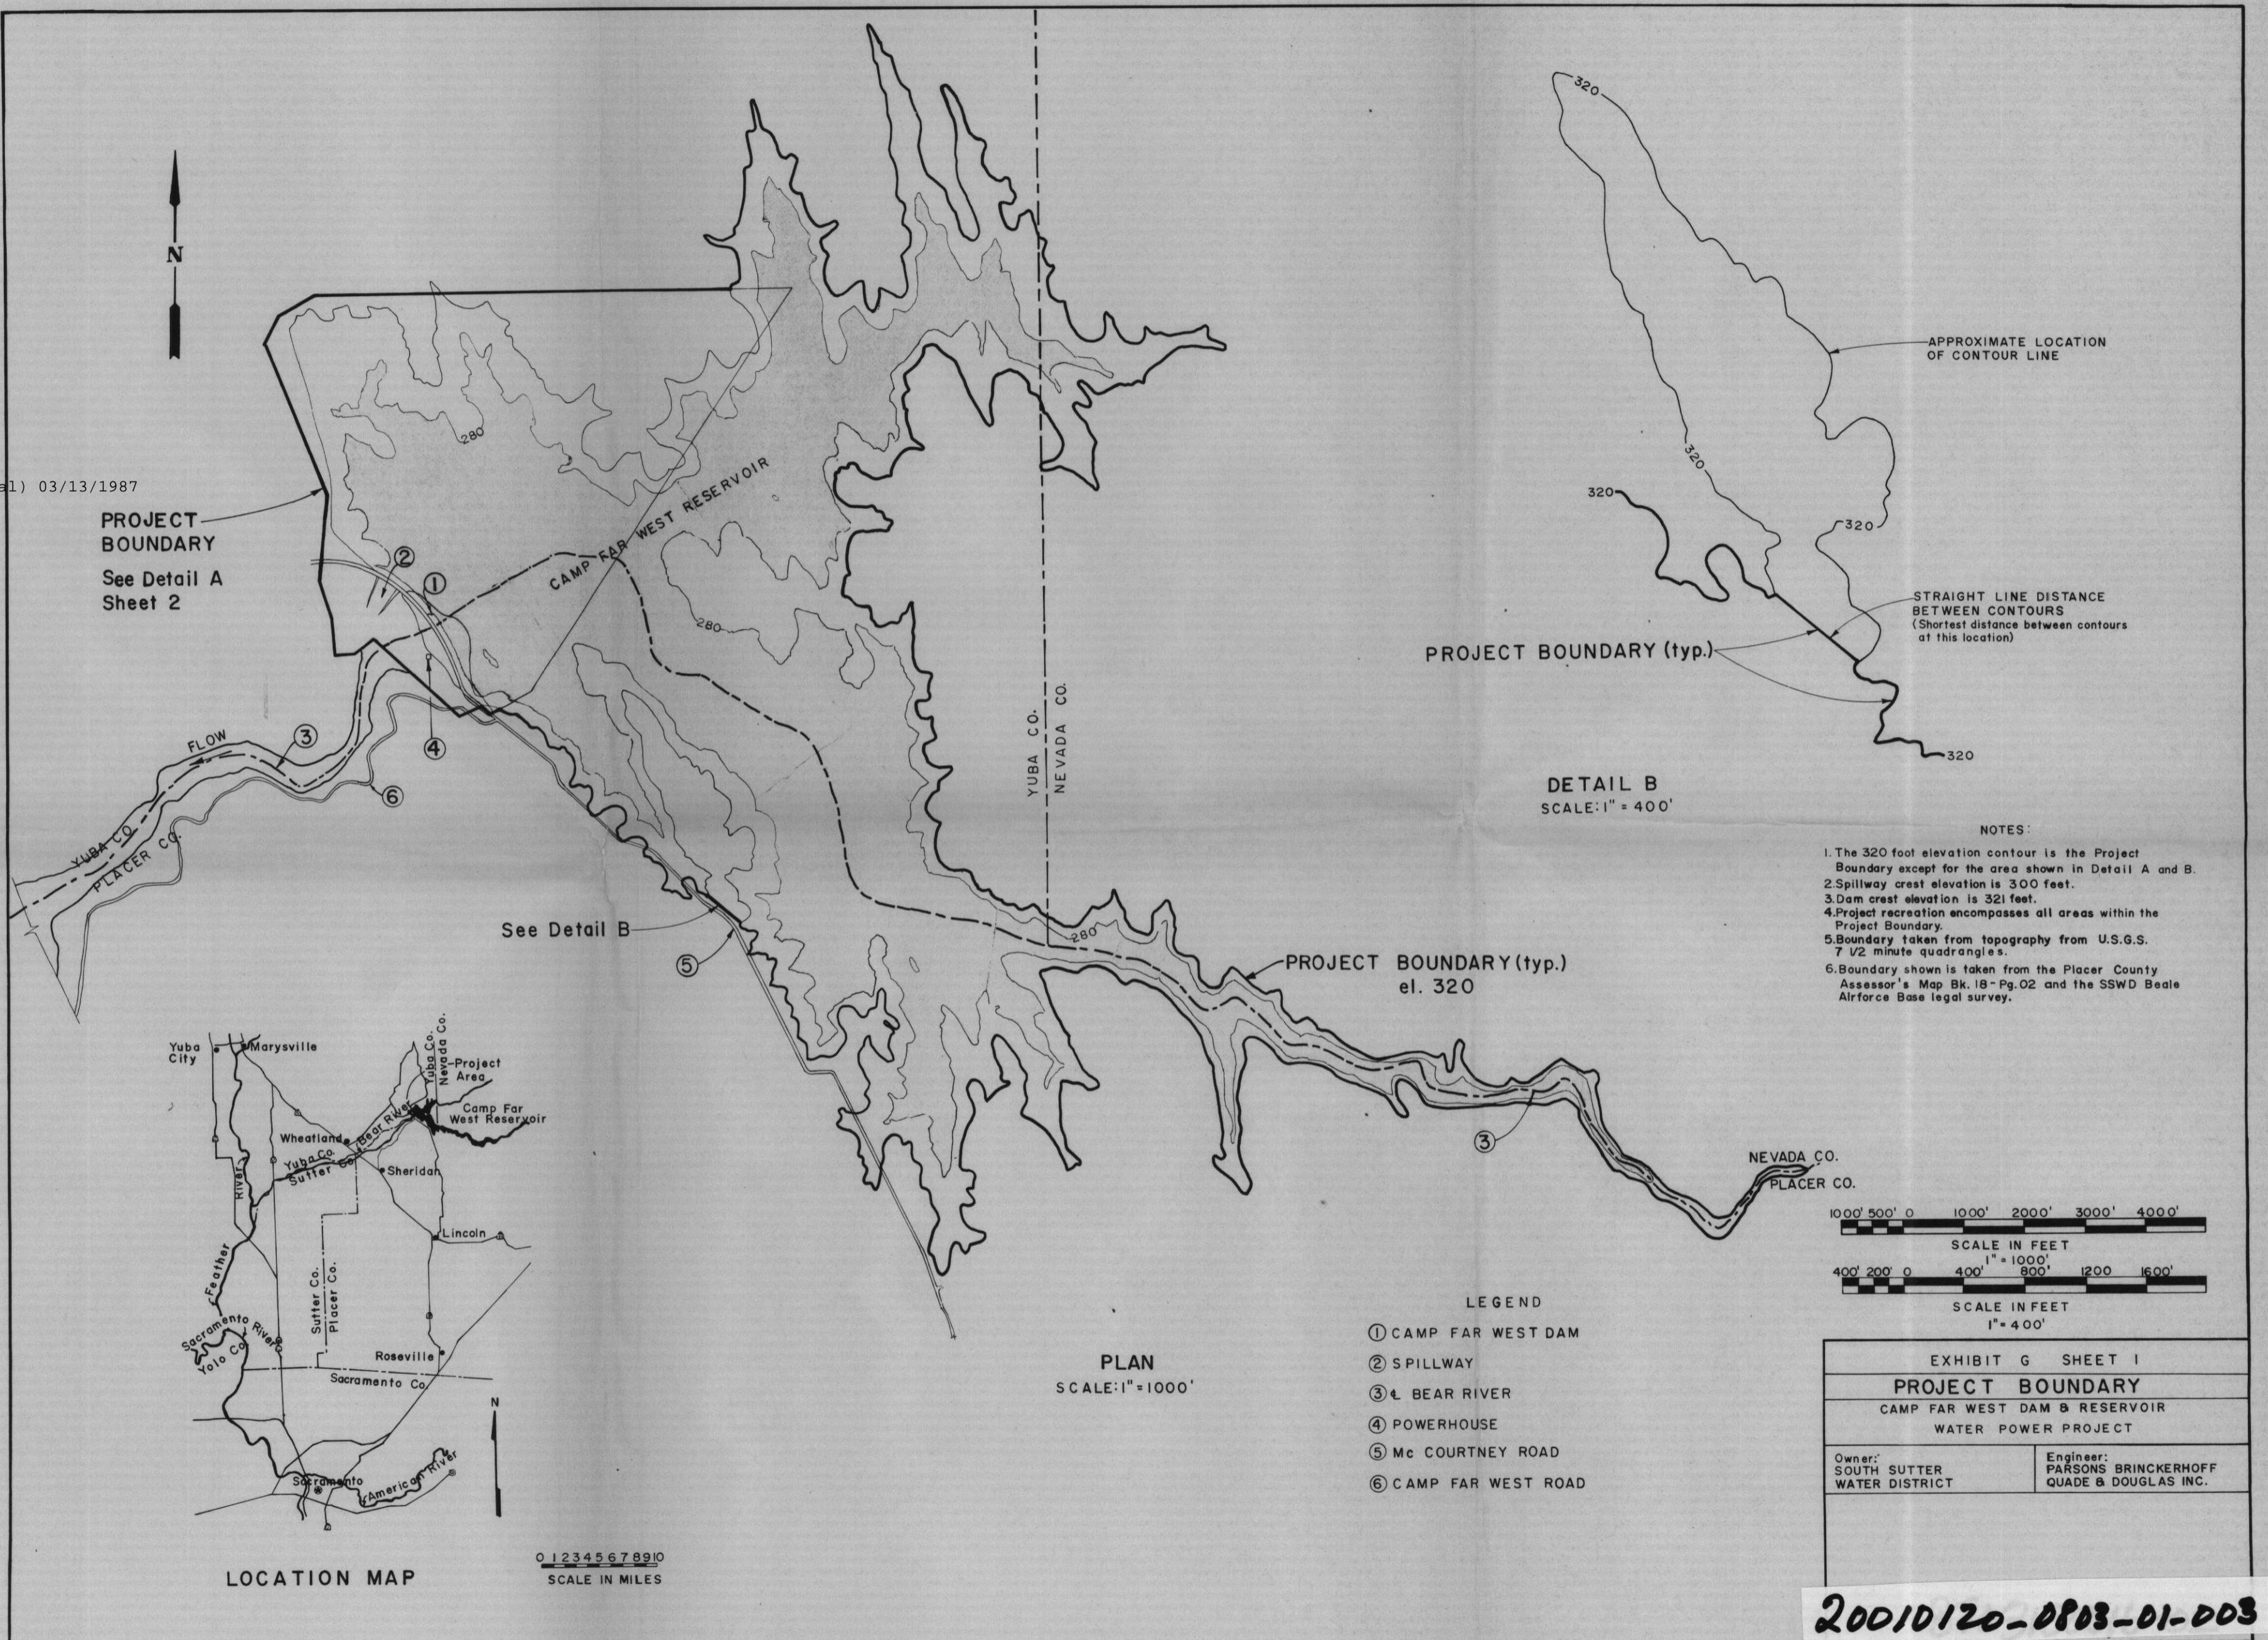

20010120-0803 FERC PDF (Unofficial) 03/13/1987

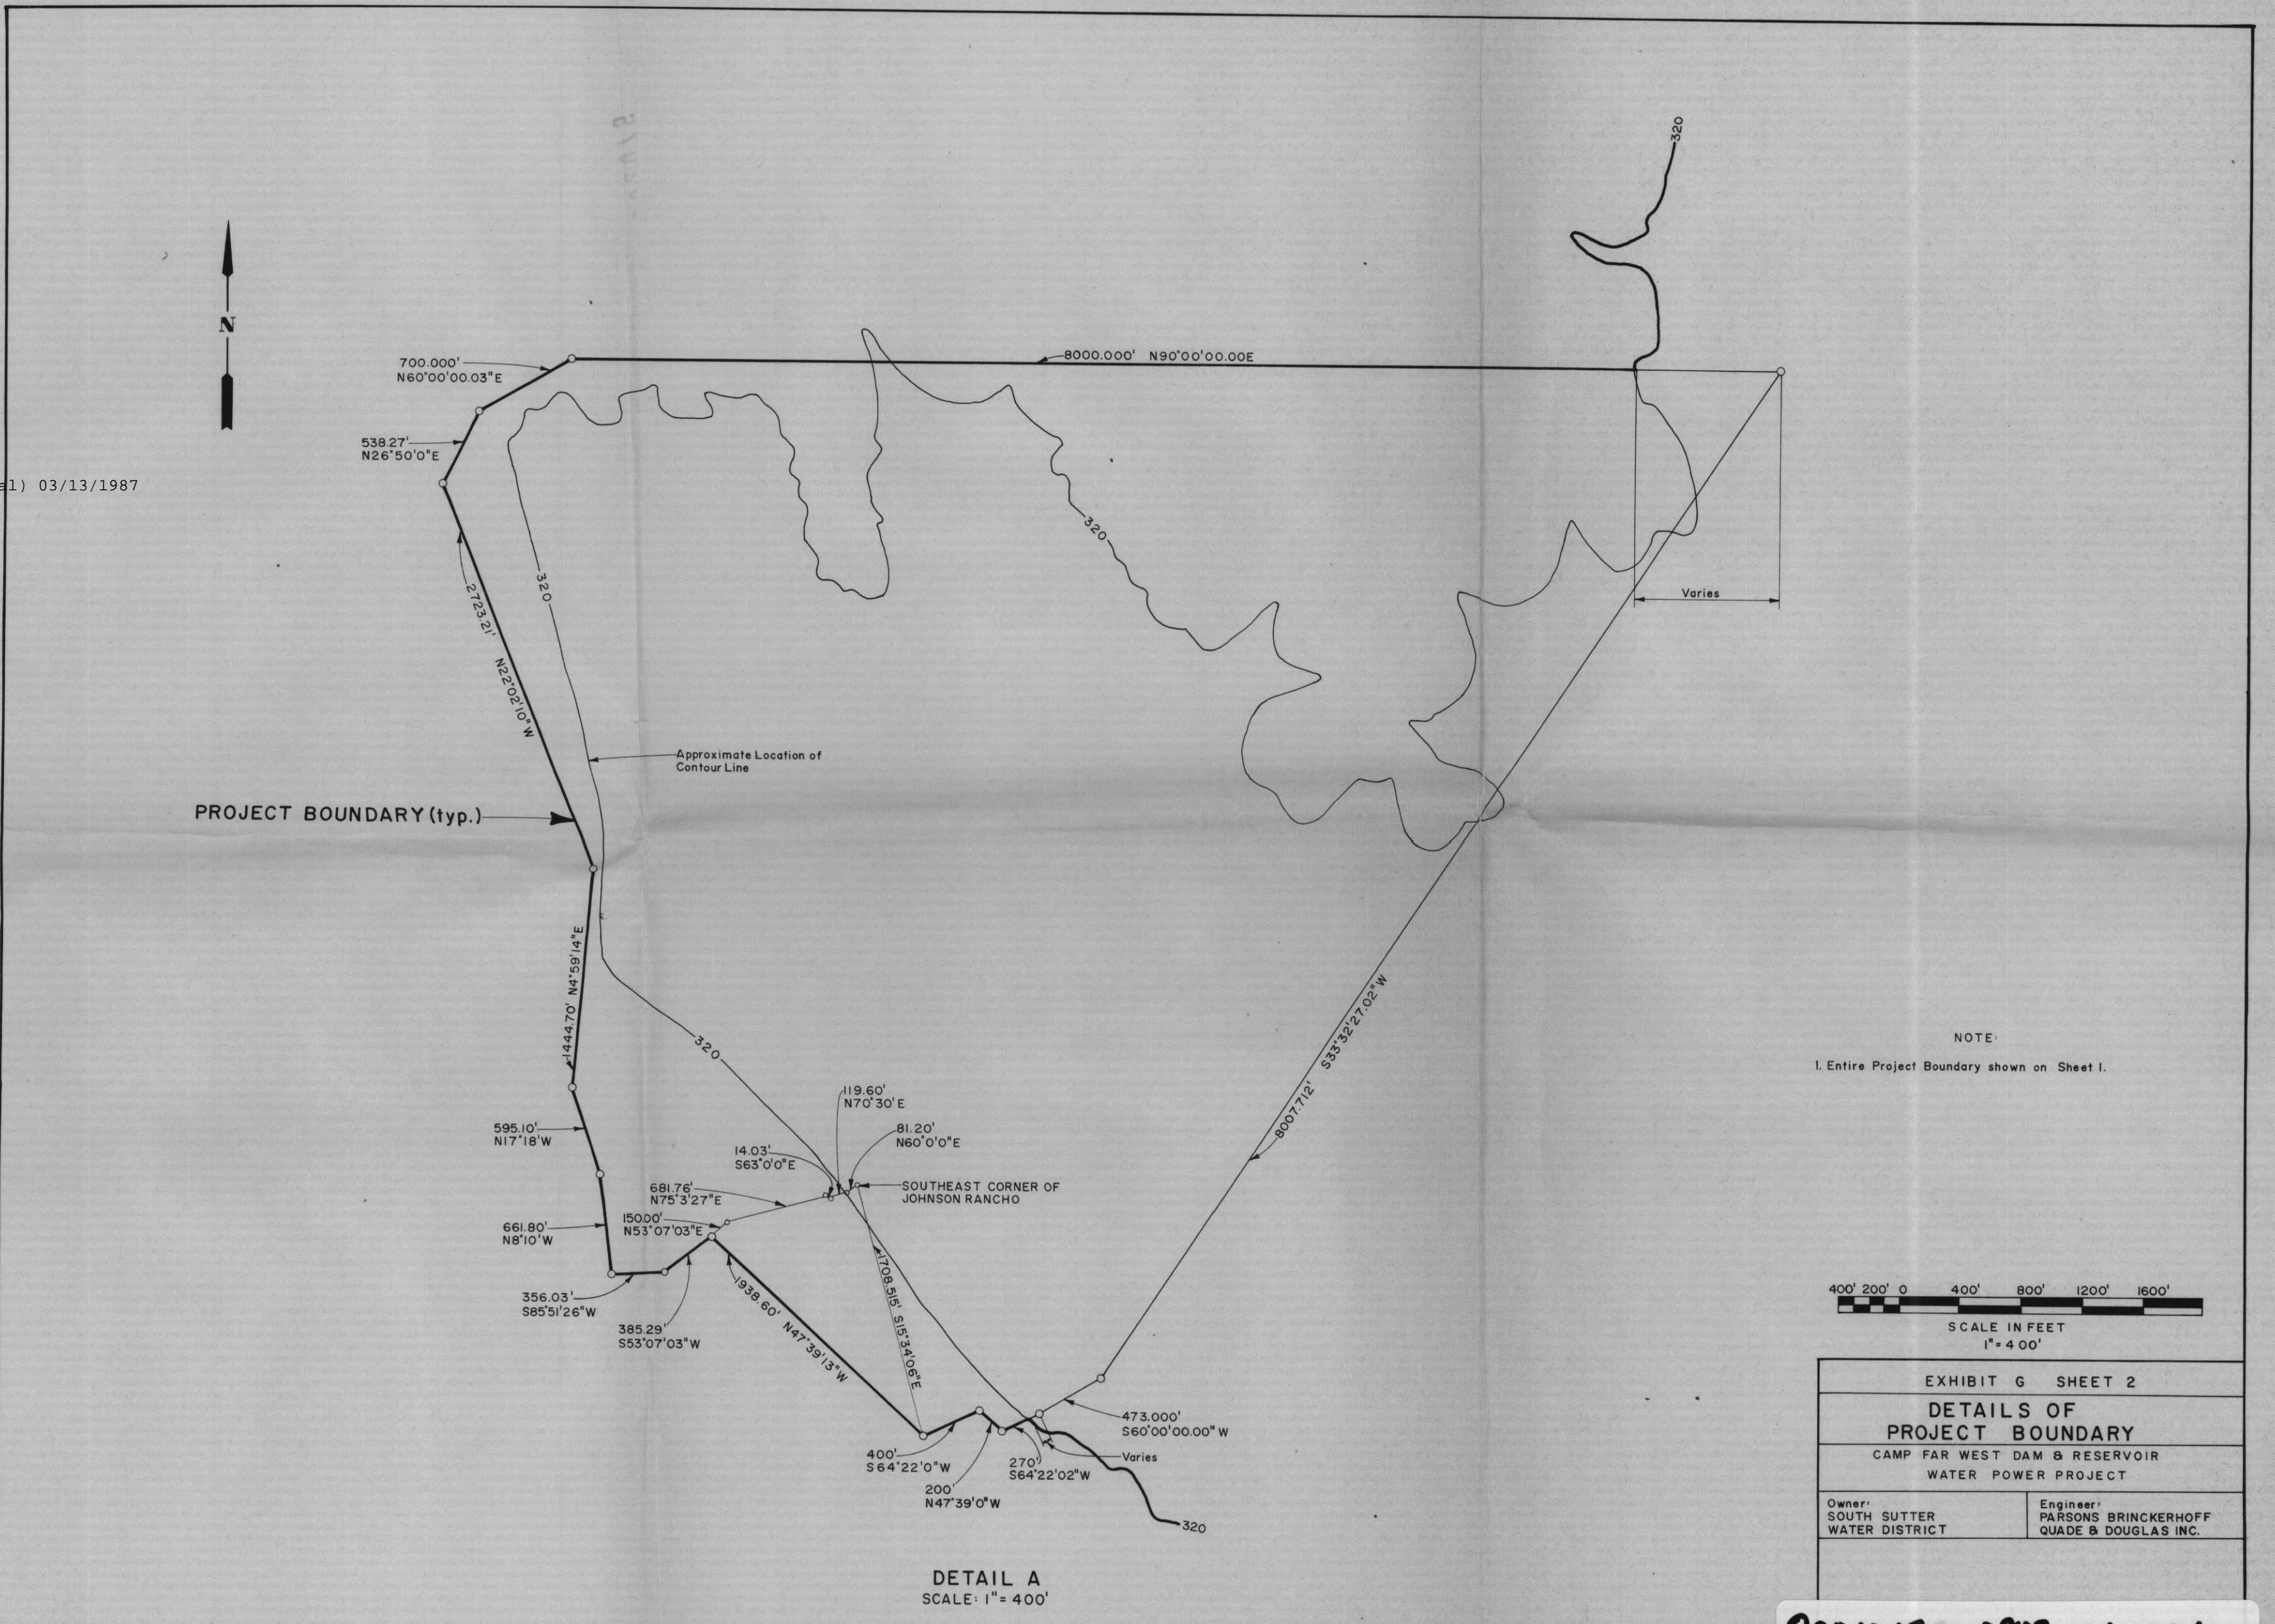

Document Content(s)

200101200803_01_001.JPG.....	1-1
200101200803_01_002.JPG.....	2-2
200101200803_01_003.JPG.....	3-3
200101200803_01_004.JPG.....	4-4